


Minneapolis Convention Center - Hall A

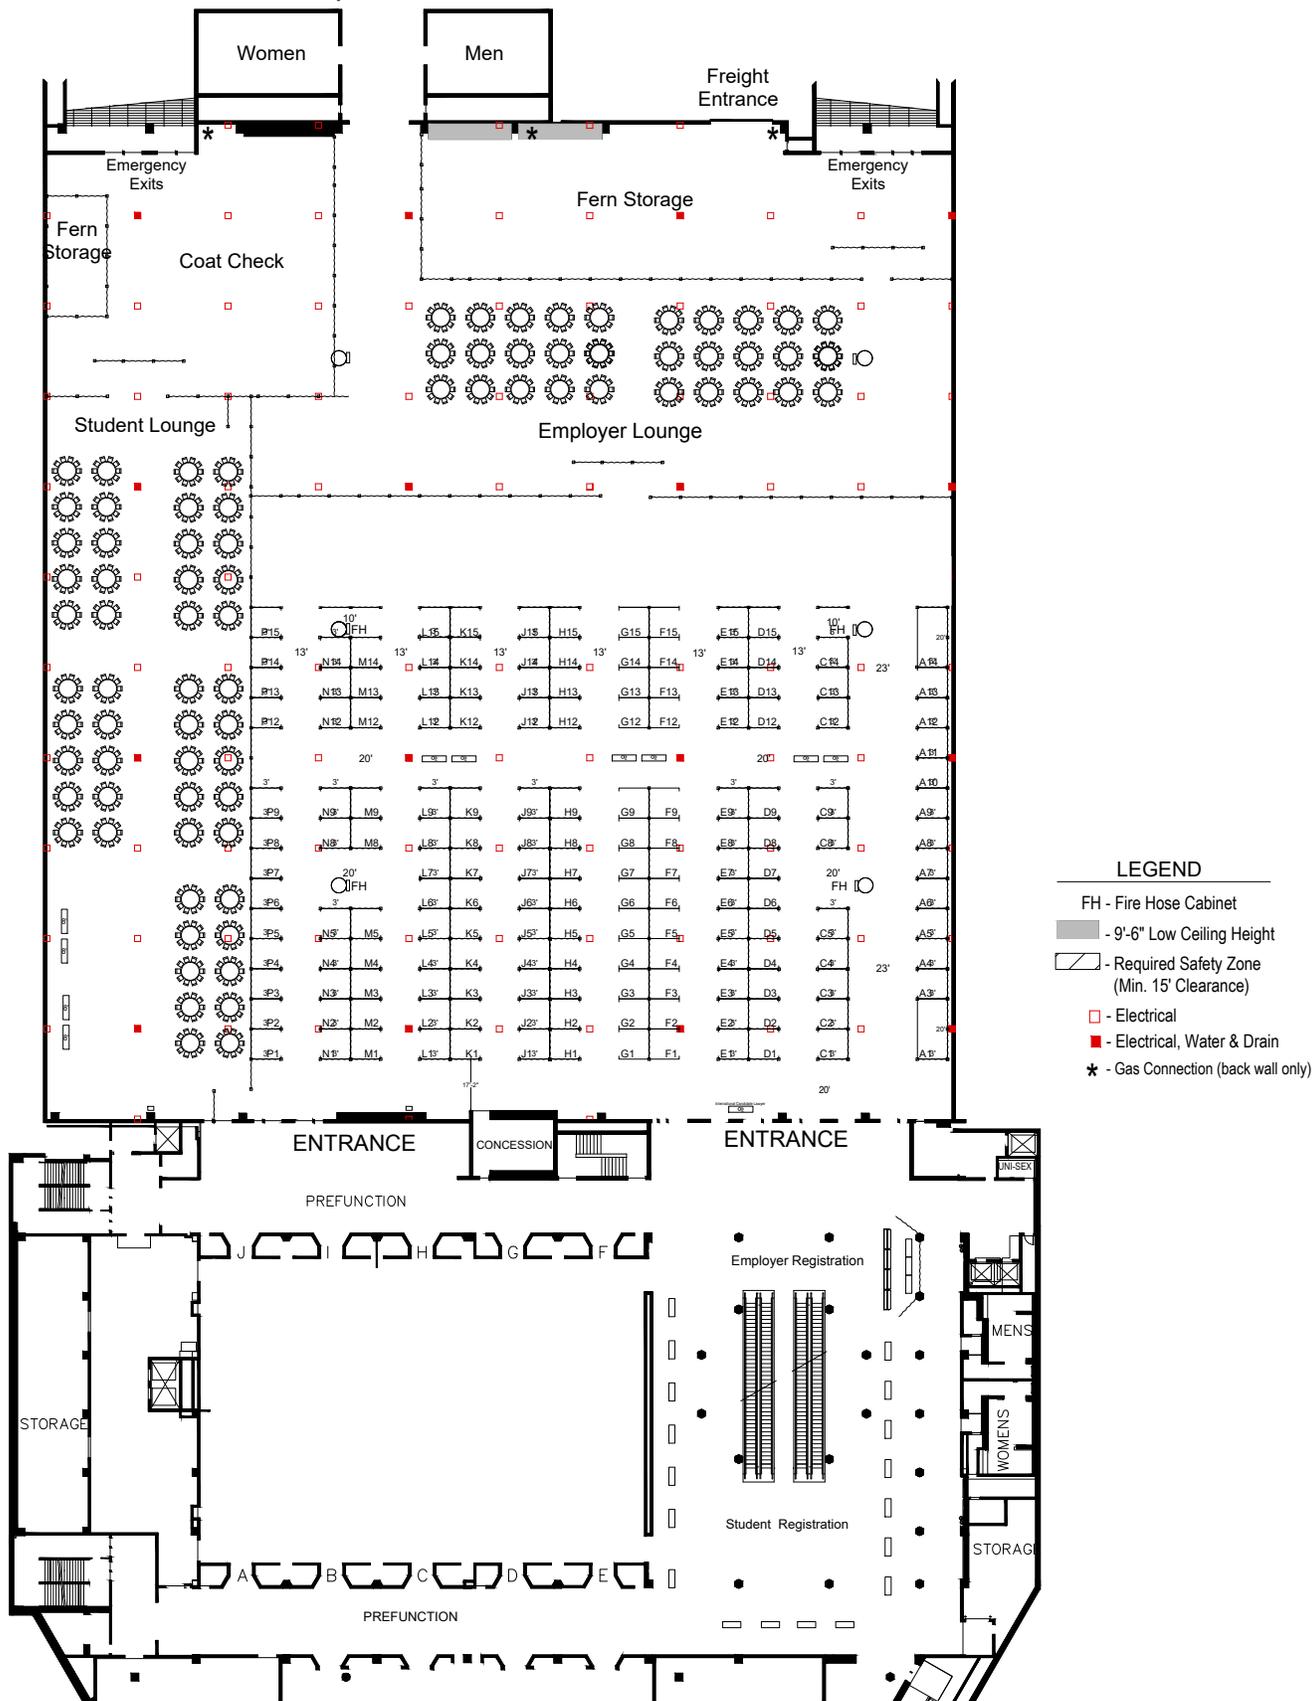

- LEGEND**
- FH - Fire Hose Cabinet
 - - 9'-6" Low Ceiling Height
 - - Required Safety Zone (Min. 15' Clearance)
 - - Electrical
 - - Electrical, Water & Drain
 - * - Gas Connection (back wall only)

Every effort has been made to ensure the accuracy of all information contained on this floor plan. However, no warranties, either expressed or implied are made with respect to this floor plan. If the location of building columns, utilities or other architectural components of the facility is a consideration in the construction of an exhibit, it is the sole responsibility of the exhibitor to physically inspect the facility to verify all dimensions and locations.

MN Private College Job & Internship Fair

Wednesday, February 18, 2026

Facility: Minneapolis Convention Center	Drawn By: HollisC
City & State: Minneapolis, MN	Show Number: 13327
Room Location: Hall A And Lobby A	Revised: 1/9/2026 8:39 AM
A.E. Tom Boehm	Drawing File: 13327_26_v01.dwg

Legend:

Pipe and Drape Report		
13327 Pipe & Drape		
02/12/2025		
Manually Placed:		
Type	Part Number	Qty
Base	10FTPOSTBASE	402
Base	8' Base	5
Upright	8FTUP	5
Upright	BP 8	230
Upright	FP 3	172
Support	8-12SUPP	4
Support	REG-R6-10	373
Description		
	10" FRONT POST BASE	
	14x16 Base	
	8' Backwall	
	BP 8 POST	
	FP 3 POST	
	8'-12' Spreader	
	REGULAR ROD 6'-10'	
Drape Panels:		
Material	Color	Qty
Banjo	Black	820
BANJO	BLUE	688
		Height
		6'
		3'

